


NO.	DESCRIPTION	DATE
1	ISSUED FOR PERMIT	11/11/2014
2	ISSUED FOR PERMIT	11/11/2014
3	ISSUED FOR PERMIT	11/11/2014
4	ISSUED FOR PERMIT	11/11/2014
5	ISSUED FOR PERMIT	11/11/2014
6	ISSUED FOR PERMIT	11/11/2014
7	ISSUED FOR PERMIT	11/11/2014
8	ISSUED FOR PERMIT	11/11/2014
9	ISSUED FOR PERMIT	11/11/2014
10	ISSUED FOR PERMIT	11/11/2014

DATE:	11/11/2014
SCALE:	AS NOTED

PROJECT:	EGRESS PLAN
----------	-------------

DATE:	11/11/2014
SCALE:	AS NOTED

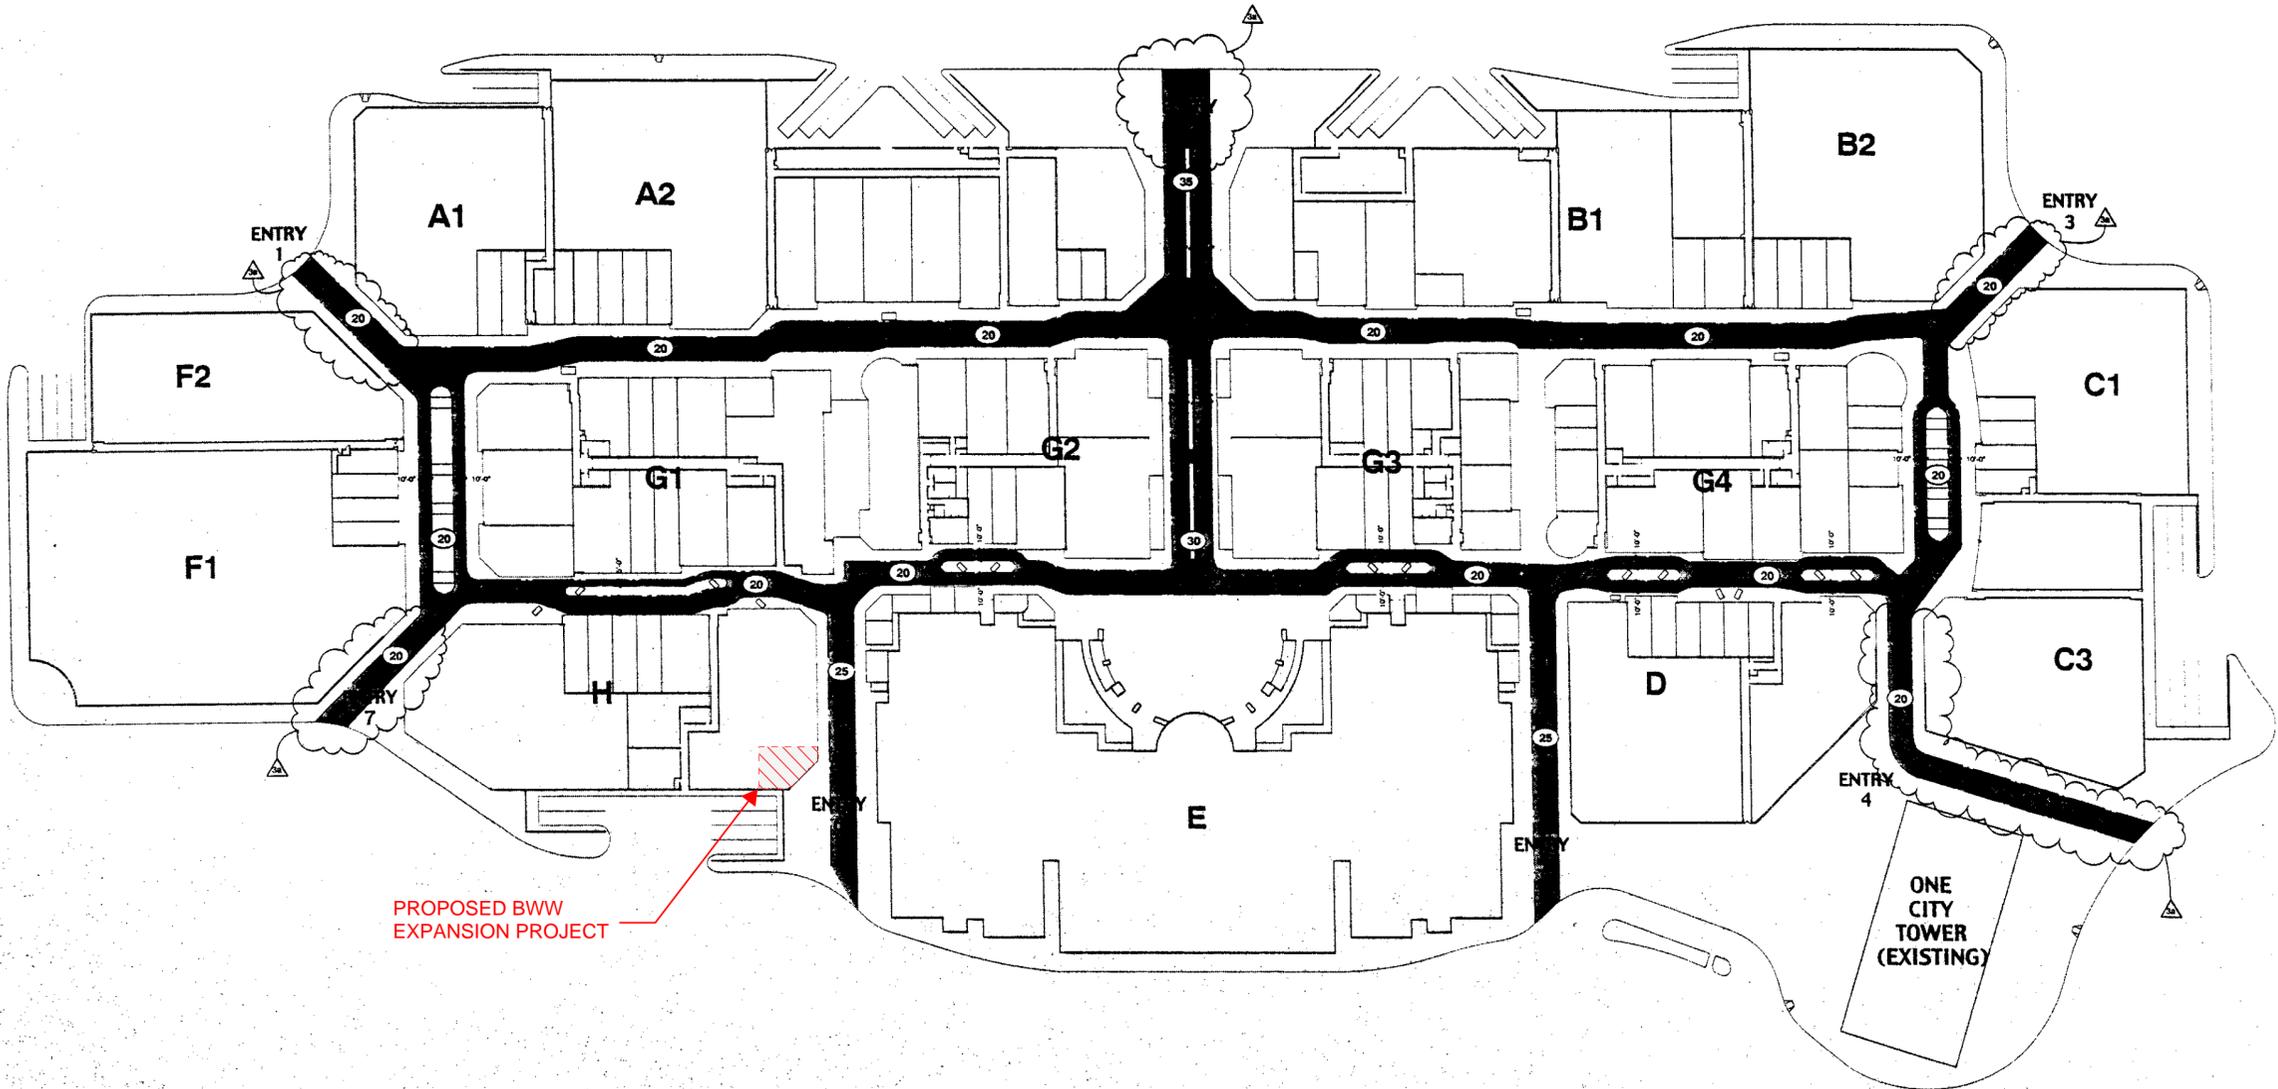


PROPOSED BWW EXPANSION PROJECT

**EGRESS PLAN LEGEND**

20 REQUIRED EGRESS WIDTH IN FEET


NOTE: SEE CODE CONSULTANTS INC. EXHIBIT B - SIMULTANEOUS EXITING ANALYSIS/FIGURE NO. 2 FOR OCCUPANT LOADS EXITING THE VARIOUS BUILDINGS, EXITING WIDTH CALCULATIONS AND EGRESS PATH.



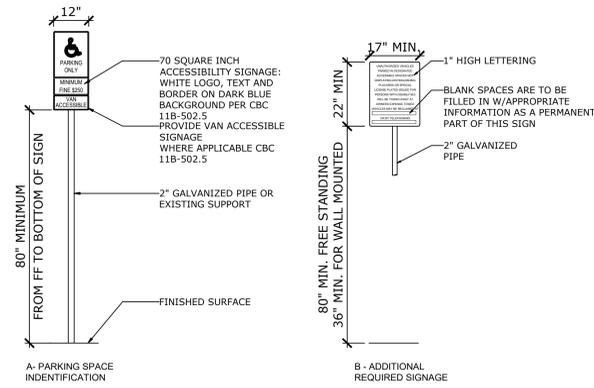


4 ACCESSIBLE PARKING SIGNAGE - EXISTING CONDITIONS  
NOT TO SCALE


NOTE: TRUNCATED DOME DETECTABLE WARNINGS SHALL CONTRAST VISUALLY WITH ADJOINING SURFACES. REFER TO CIVIL DRAWINGS FOR ADDITIONAL INFORMATION.

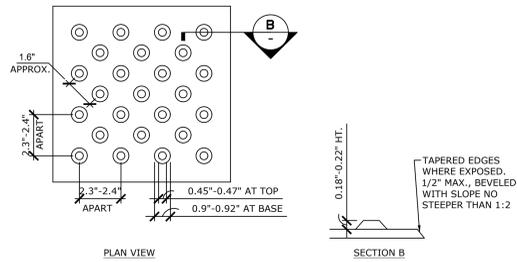

3 DETECTABLE WARNINGS  
NOT TO SCALE

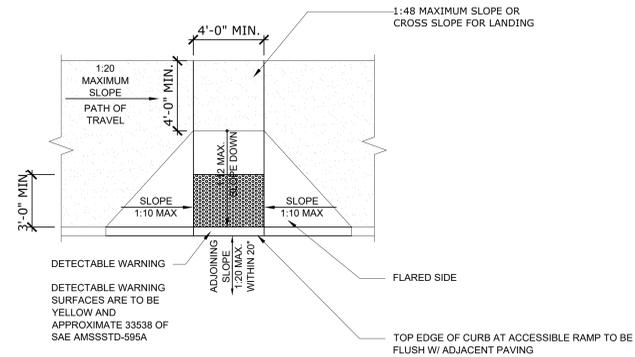


2 CURB RAMP - EXISTING CONDITIONS  
NOT TO SCALE

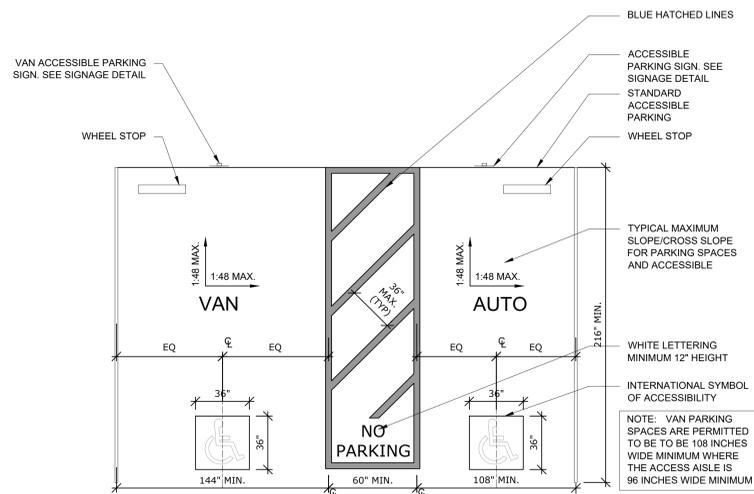

NOTE: - PARKING STALLS SHALL COMPLY WITH CBC 2019 §11B-208 AND 11B-502

1 ACCESSIBLE PARKING REQUIREMENTS - EXISTING CONDITIONS  
NOT TO SCALE

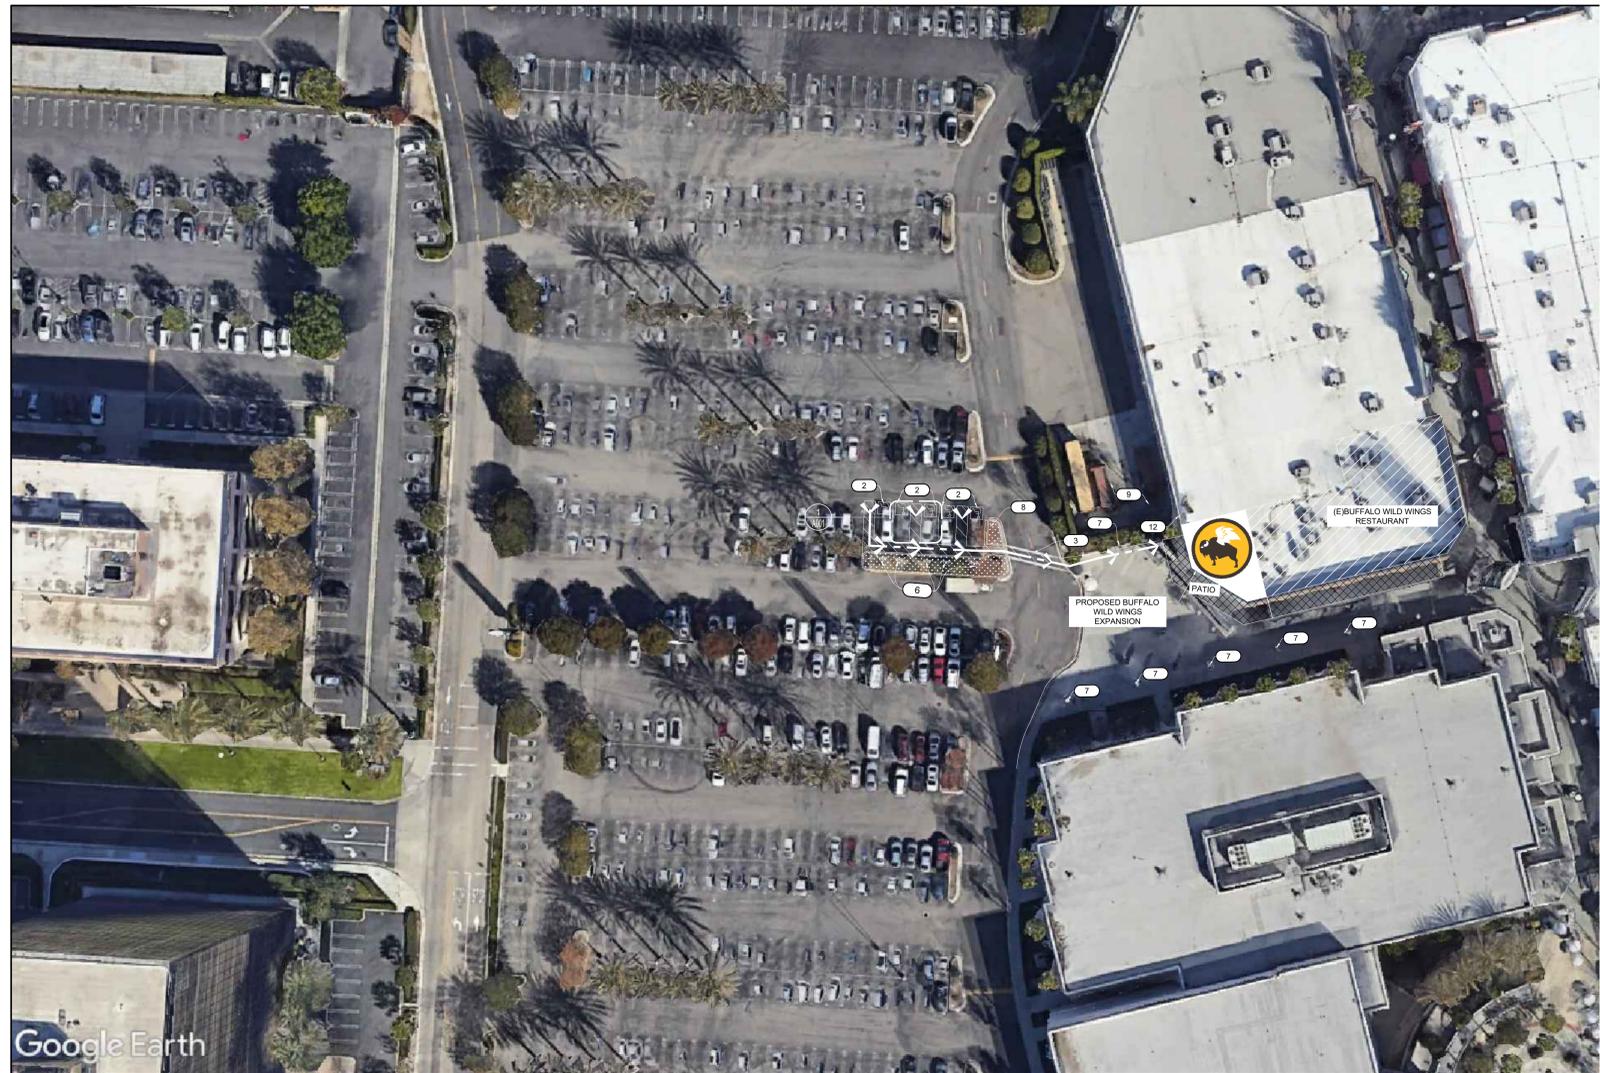

3D ARCHITECTURAL SITE PLAN  
1/32" = 1'-0"

#	KEY NOTES	#
1.	NOT USED	
2.	EXISTING ACCESSIBLE PARKING STALL. SEE DETAIL, 1/A001.	
3.	EXISTING ACCESSIBLE PATH OF TRAVEL TO PUBLIC WAY AND TO RESTAURANT. PATH OF TRAVEL SHALL COMPLY WITH THE EXISTING PATH OF TRAVEL REQUIREMENTS SECTION NOTED BELOW. NOTIFY ARCHITECT AND OWNER IF PATH OF TRAVEL DOES NOT COMPLY.	
4.	EXISTING TRANSFORMER	
5.	EXISTING WATER METER	
6.	EXISTING ADA PARKING SIGN. SEE DETAIL, 4/A001.	
7.	SITE LIGHT POLE	
8.	EXISTING LANDSCAPING	
9.	EXISTING TRASH ENCLOSURE	
10.	EXISTING CURB RAMP	
11.	EXISTING ZERO CURB ACCESS	
12.	GAS LINE AND METER LOCATION - SEE PLUMBING SHEETS AND UTILITY REQUIREMENTS NOTES THIS SHEET	

CONSULTANT:

**Menemsha**

LOS ANGELES | BOSTON  
20521 EARL STREET  
TORRANCE, CA 90503  
Voice: 310-263-3516  
Fax: 775-890-9954  
www.menemshasolutions.com

Plans, maps, specifications, studies and reports not containing a seal are not intended to be used for construction. The seal of the professional engineer or architect is required for the professional engineer or architect to be used for the design of any structure or system. All drawings and reports shall be prepared by the professional engineer or architect who is responsible for the design and shall not be used for any other purpose without the written consent of the architect and shall not be reproduced, used or disclosed without written consent of the architect. Copyright Protected 2020.

CERTIFICATION

**PRELIMINARY**  
NOT-FOR-CONSTRUCTION

REGISTRATION NUMBER

XX.XX

EXP. DATE

XX.XX.XX

PROJECT NUMBER

26593

**BUFFALO WILD WINGS**  
FRANCHISE - IN LINE  
THE OUTLETS AT ORANGE  
20 CITY BLVD., SUITE 901 E  
ORANGE, CA 92668  
6.5K PROTOTYPE V20.1.10



3 GLENLAKE PARKWAY NE  
BWW DESIGN TEAM  
ATLANTA, GA 30328  
PHONE 678.514.4100

DRAWING ISSUE

NO	DATE	DESCRIPTION
1	04-04-2023	
2		
3		
4		
5		
6		

Drawing Title  
**ARCHITECTURAL**  
SITE PLAN &  
DETAILS

**A001**

LEGEND	
	PATH OF TRAVEL FROM ACCESSIBLE PARKING STALL TO FRONT DOOR
	ACCESSIBLE PARKING AND SIGNAGE
	PATIO
	AREA OF RENOVATION
	EXISTING BWW RESTAURANT
	EXISTING LANDSCAPING



**Project Owner:**



**Consultant:**

**Menemsha SOLUTIONS**

LOS ANGELES OFFICE  
20521 EARL STREET  
TORRANCE, CA 90503  
T. 310-343-3430

BOSTON OFFICE  
370 LIBBEY INDUSTRIAL PARKWAY  
UNIT 600  
WEYMOUTH, MA 02189  
T. 781-337-9012  
www.menemshasolutions.com

Plans, maps, specifications, studies, and reports not containing a wet ink seal imprint accompanied by an original signature by the licensed professional may have been fraudulently altered and shall not be considered an original copy. All information should be disregarded unless verified by the professional whose signature appears above. All drawings and written material appearing herein constitute original and unpublished work of the architect and may not be duplicated, used or disclosed without written consent of the architect. Copyright Protected 2022.

**Project Address:**

BWW - EXPANSION  
20 CITY BLVD EAST #901  
ORANGE, CA 92868

**Stamp:**

No.	Date	Description

**Sheet Title:**

VIRTUAL TOUR &  
PHOTO FLOOR KEY  
PLAN

DRAWN BY: HC

DWG. DATE: 09.14.22

REVIEWED BY: STO


PROJECT NUMBER: 26593

TEMPLATE TYPE:

SHEET:


**A101**

- 14-25 → 3 SUB-PANELS LOCATED AT KITCHEN
- 26-29 → FIRE ALARM SYSTEM LOCATED AT MANAGER'S OFFICE
- 30-32 → 1 SUB-PANEL LOCATED AT MANAGER'S OFFICE
- 33 → PHONE / DATA BOARD LOCATED AT MANAGER'S OFFICE
- 34 → MEZZANINE LEVEL
- 35-38 → WATER HEATER LOCATED AT MEZZANINE LEVEL
- 39-47 → MAIN DISTRIBUTION PANEL LOCATED AT MEZZANINE LEVEL
- 48-51 → ELECTRICAL TRANSFORMER LOCATED AT MEZZANINE LEVEL
- 52-55 → 1 SUB-PANEL LOCATED AT MEZZANINE LEVEL
- 56-59 → GAS METER - LOCATED AT SOUTH WALL OF LOADING AREA
- 60-65 → SWITCH GEAR & ELECTRICAL METER LOCATED AT ELECTRICAL ROOM
- 66-68 → FIRE RISER ROOM

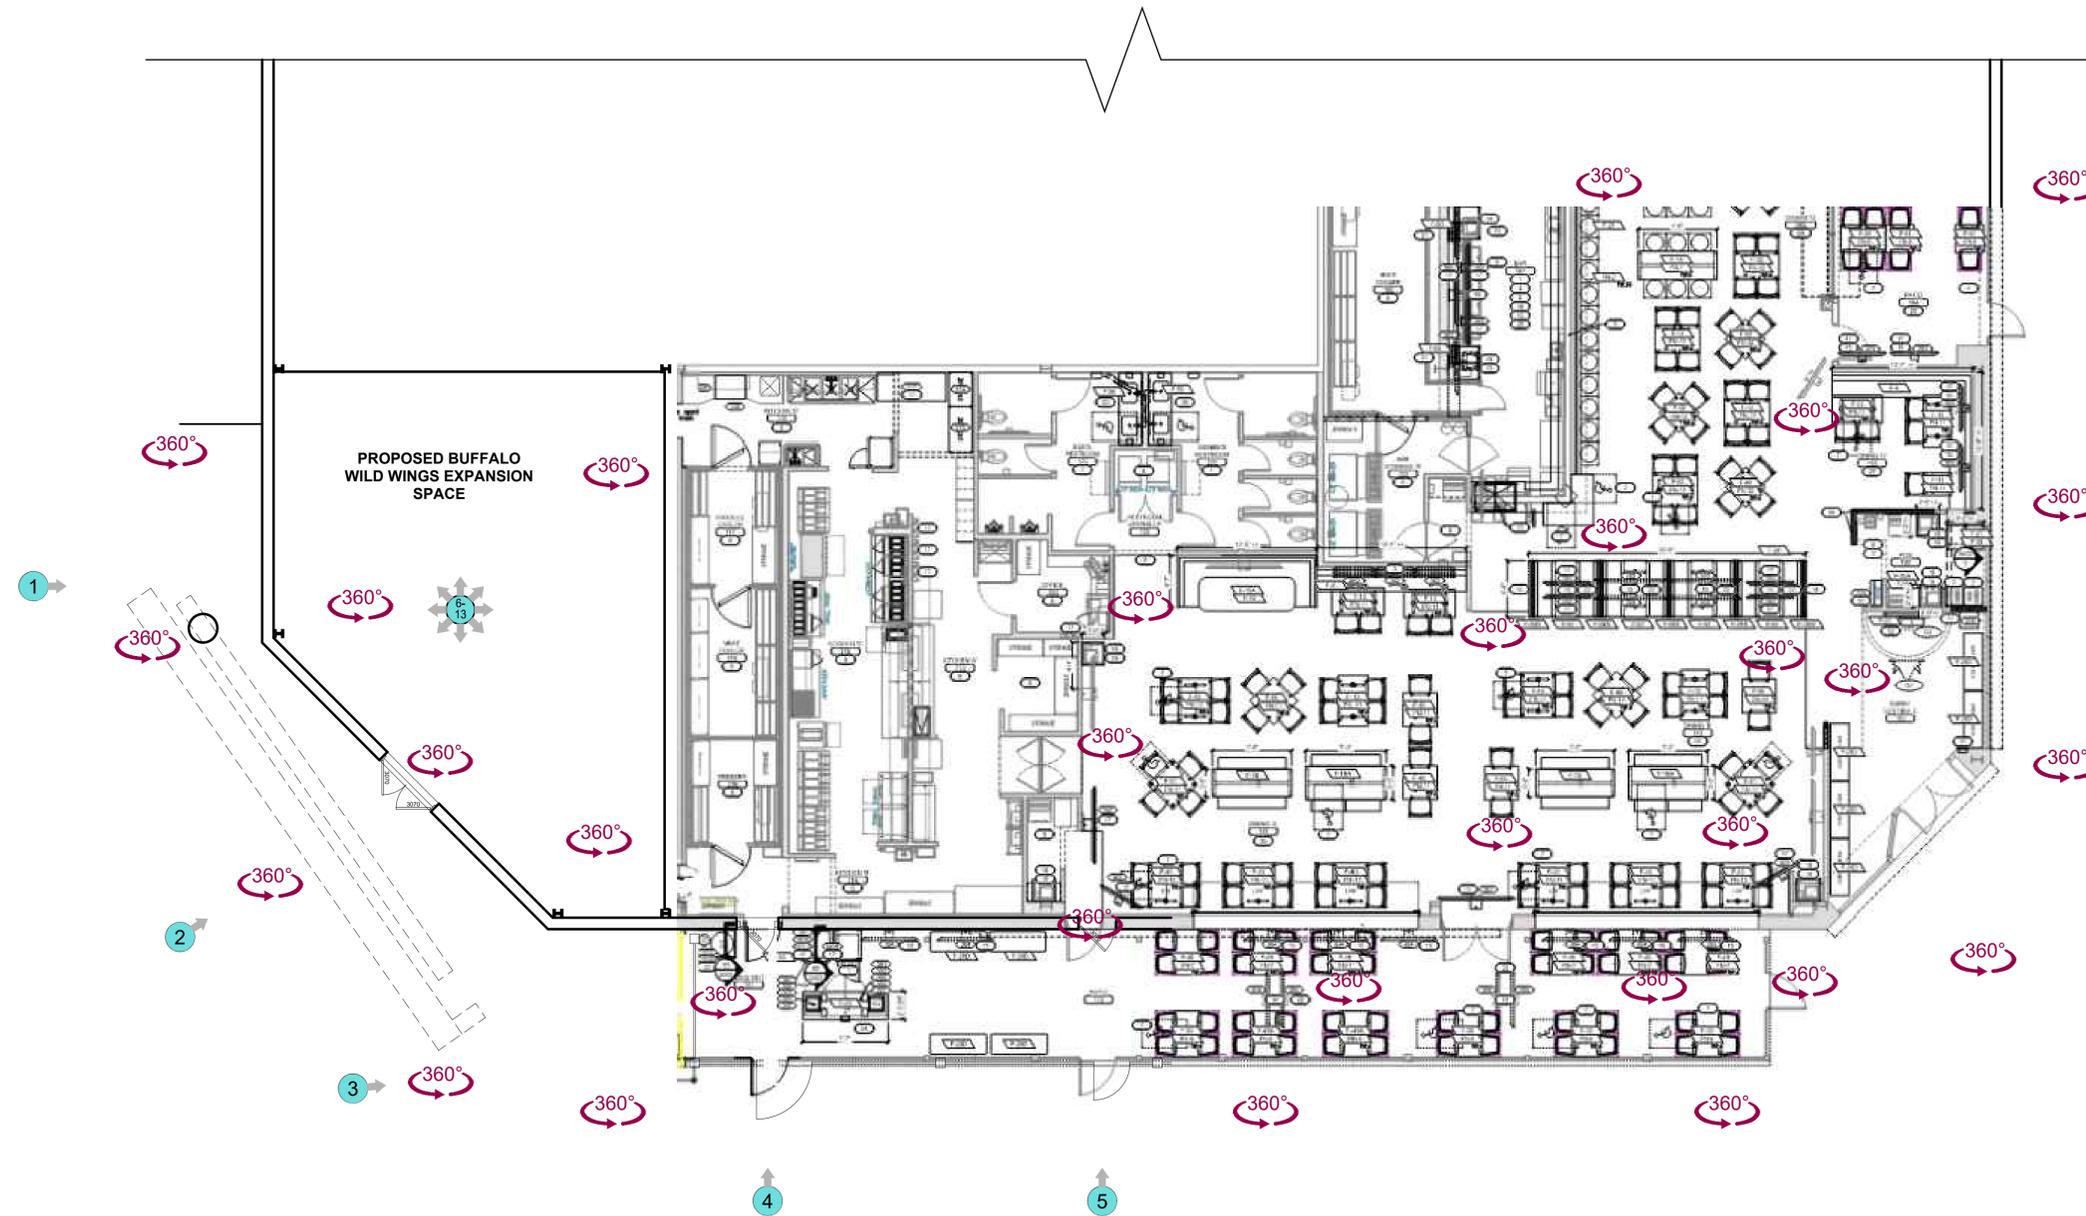

LINK TO VIRTUAL WALKTHROUGH (PDF DRAWING VERSION ONLY) CLICK ON THE ICON TO OPEN A 360° PANORAMIC IMAGE IN YOUR WEB BROWSER

STILL PHOTO LINK (PDF DRAWING VERSION ONLY) CLICK ON THE STILL PHOTO LINK TO VIEW THE IMAGE ON YOUR PHOTO MANAGEMENT SOFTWARE

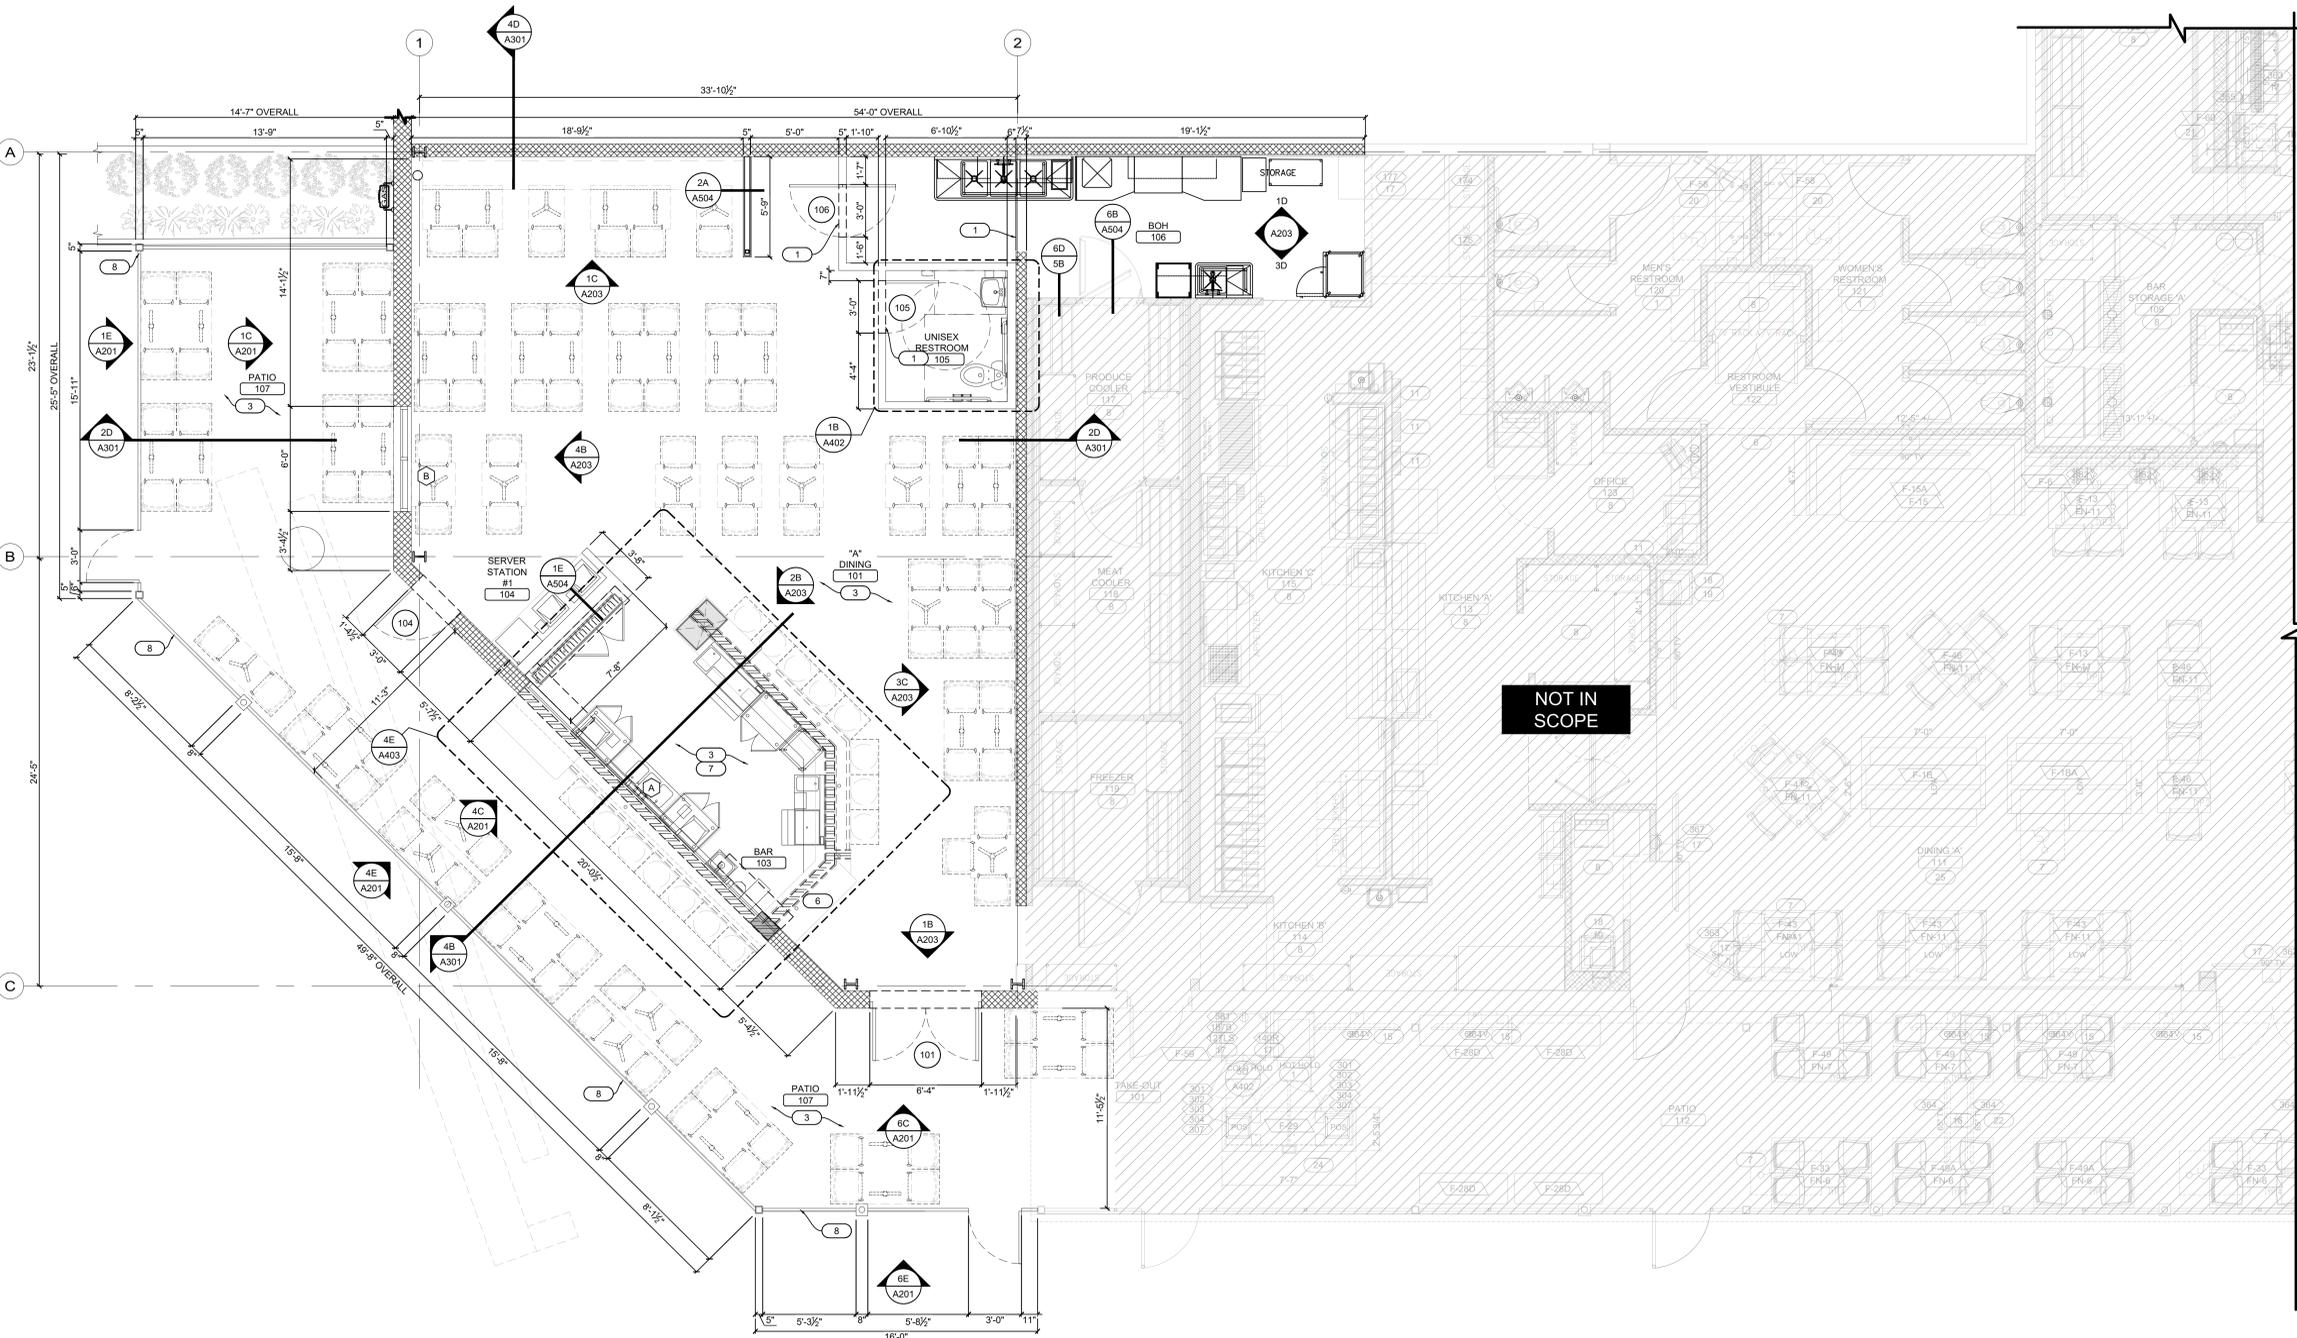

1E DEPICTIVE FLOOR PLAN  
1/4" = 1'-0"

KEY NOTES

- 1 BULKHEAD OR SOFFIT ABOVE. SEE CEILING PLAN
- 2 6" DIA. PVC CHASE FOR SODA LINES. SEE 1A/A504
- 3 REFER TO CEILING PLAN FOR TELEVISION LOCATIONS
- 4 INSTALL BELL AT DOOR, REFER TO ELEC. FOR CHIME LOCATION.
- 5 WALK IN BOXES PROVIDED BY EQUIPMENT VENDOR. COORDINATE INSTALLATION. WALLS SURROUNDING COOLERS SHALL HAVE MOLD RESISTANT GYPSUM BOARD (GWB-2) ABUTTING COOLER WALL. REFERENCE ELECTRICAL FOR LINE VOLTAGE/LOW VOLTAGE REFRIGERATION SCOPE.
- 6 30" HIGH ACCESSIBLE COUNTERTOP, SEE 1B/A403
- 7 SEE ENLARGED BAR PLAN FOR DETAILS - A403
- 8 METAL PATIO RAILING - REFERENCE EXTERIOR ELEVATIONS AND 2A/A501
- 9 LOCATION OF OCCUPANT LOAD SIGN. POST AT +8'-0" AFF.
- 10 HOST STAND / FEATURE WALL BY MILLWORK VENDOR - SEE WINDOW TYPE ON A601 FOR GLASS PANEL INFORMATION AND DETAIL 4A/A507 FOR MORE INFORMATION
- 11 3" CLEAR MIN REQUIRED FROM FINISHED FACE OF WALL TO EDGE OF HOOD.
- 12 GREASE RECOVERY SYSTEM - ON FLAT 4" HIGH CONC. PAD, SEE STRUCTURAL AND PLUMBING FOR DETAILS, ROUGH-IN INFORMATION, SCOPE OF WORK, ETC
- 13 ROOF LADDER / HATCH - SEE DETAIL 3E/A504.
- 14 INSTALL BUZZER AT EXTERIOR KITCHEN DOOR, REFER E201 FOR CHIME LOCATION.
- 15 CONCRETE CURB BELOW ELECTRICAL PANELS - REF 5E/A504
- 16 NOT USED
- 17 NOT USED
- 18 FUTURE HEATED PASS-THRU HOLDING LOCKERS FOR TO-GO ORDERS - SEE A405, EQ101, AND ELECTRICAL DWGS FOR MORE INFORMATION
- 19 CURTAINS AND TRACK (MC-1) AT MVP ROOM OPENING
- 20 NOT USED
- 21 BUG SCREEN AT GARAGE DOORS - SEE A601

GENERAL NOTES

- 1. REFER TO A102 FOR FRAMING PLAN.
- 2. REFER TO A103 FOR WALL SHEATHING AND FINISH INFORMATION.
- 3. REFER TO A601 FOR WINDOW, DOOR, AND FRAME INFORMATION.
- 4. ALL DIMENSIONS ARE TO FACE OF FRAMING, UNLESS NOTED OTHERWISE.
- 5. ENTRY AND PATIO DOORS TO BE FULLY ACCESSIBLE - CLEAR AREA REQUIRED AT DOOR TO BE LEVEL OR 2% SLOPE MAXIMUM DOOR PULLS MOUNTED AT 48" AFF.
- 6. ALL LOW WALLS IN DINING SPACE WITH POSTS SHOWN IN PLAN - REF 3B ON A505 FOR MORE EMBEDMENT INFORMATION.

CONSULTANT:

**Menemsha**

LOS ANGELES | BOSTON  
20521 EARL STREET  
TORRANCE, CA 90503  
Voice: 310-263-3516  
Fax: 775-890-9954  
www.menemshasolutions.com

Plans, specs, specifications, studies and reports not constituting a contract shall remain the property of the consultant. No part of this document shall be reproduced or transmitted in any form or by any means electronic or mechanical, including photocopying, recording, or by any information storage and retrieval system, without the prior written consent of the consultant. Copyright Protected 2020.

CERTIFICATION

REGISTRATION NUMBER  
XX.XX  
EXP DATE  
XX.XX.XX  
PROJECT NUMBER  
26593

**BUFFALO WILD WINGS**  
FRANCHISE - IN LINE  
THE OUTLETS AT ORANGE  
20 CITY BLVD., SUITE 901 E  
ORANGE, CA 92668  
6.5K PROTOTYPE V20.1.0



3 GLENLAKE PARKWAY NE  
BWW DESIGN TEAM  
ATLANTA, GA 30328  
PHONE 678.514.4100


DRAWING ISSUE

NO	DATE	DESCRIPTION
1	03-27-2023	PLANNING DEPARTMENT SET
2		
3		
4		
5		
6		

Drawing Title

DEPICTIVE AND  
DIMENSION  
PLAN

A101

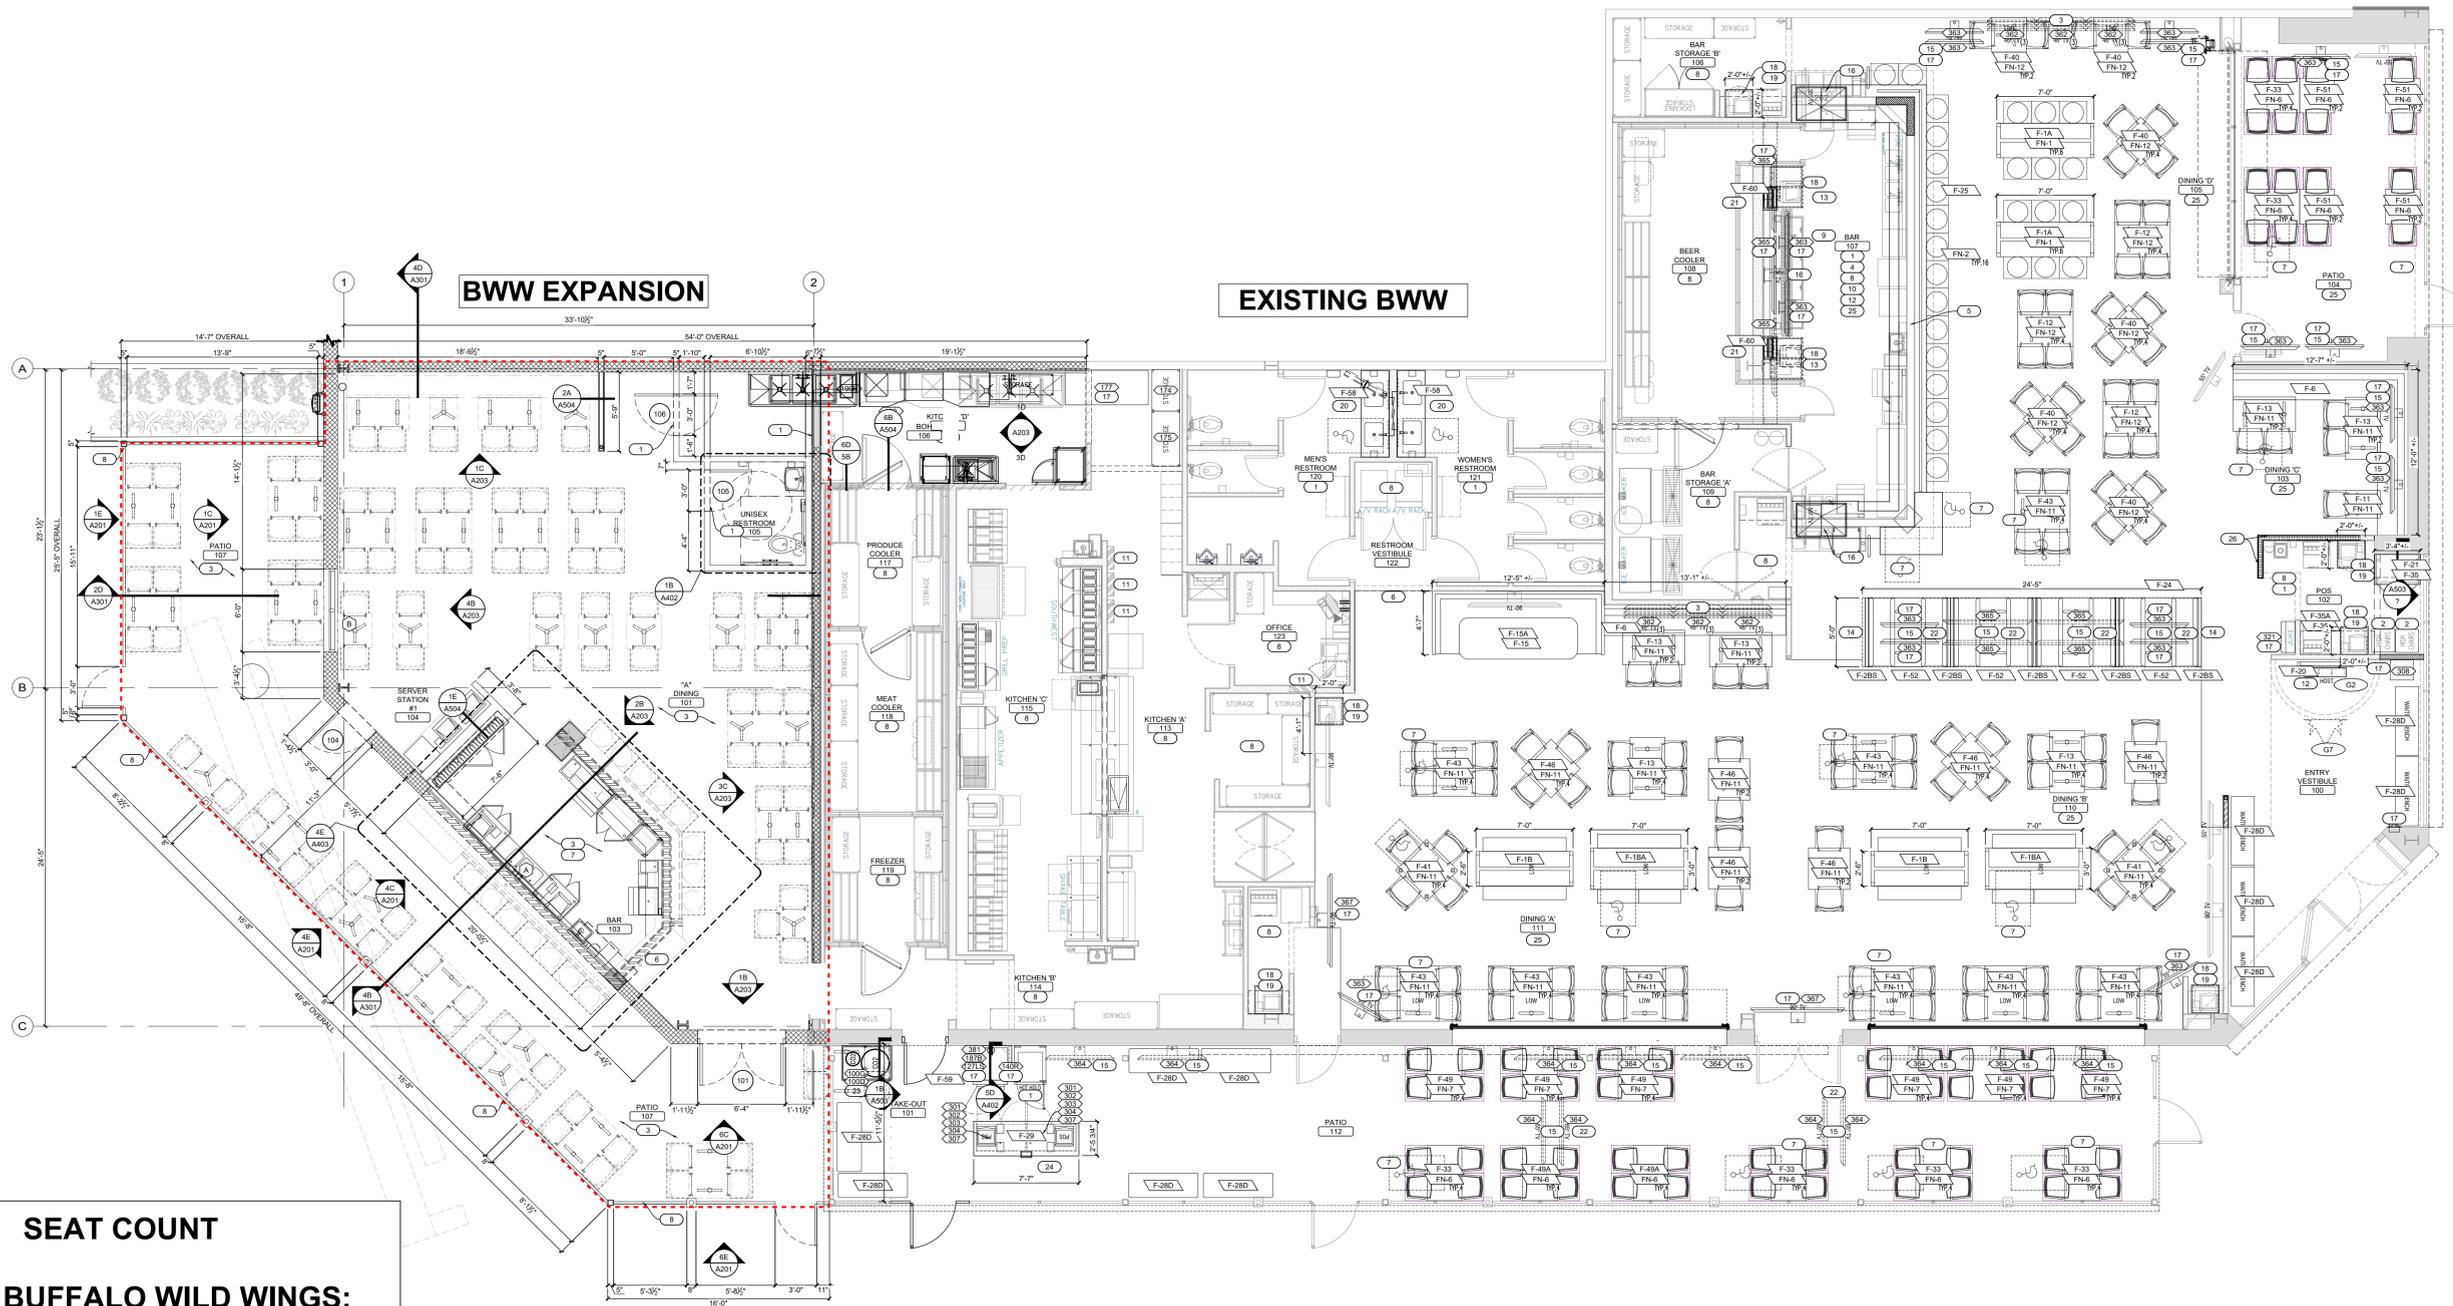

**BWV EXPANSION**

**EXISTING BWV**

**SEAT COUNT**

**EXISTING BUFFALO WILD WINGS:**

PATIO: 64  
 INTERIOR: 192 (BAR SEATING: 18)  
 TOTAL: 256

**BUFFALO WILD WINGS EXPANSION:**

PATIO: 54 (BAR SEATING: 8)  
 INTERIOR: 66 (BAR SEATING: 9)  
 TOTAL: 120

**TOTAL SEATS: 372**

1F DEPICTIVE FLOOR PLAN  
 NTS

**BUFFALO WILD WINGS**  
 20 CITY BLVD. SUITE 901  
 ORANGE, CA 92868